

 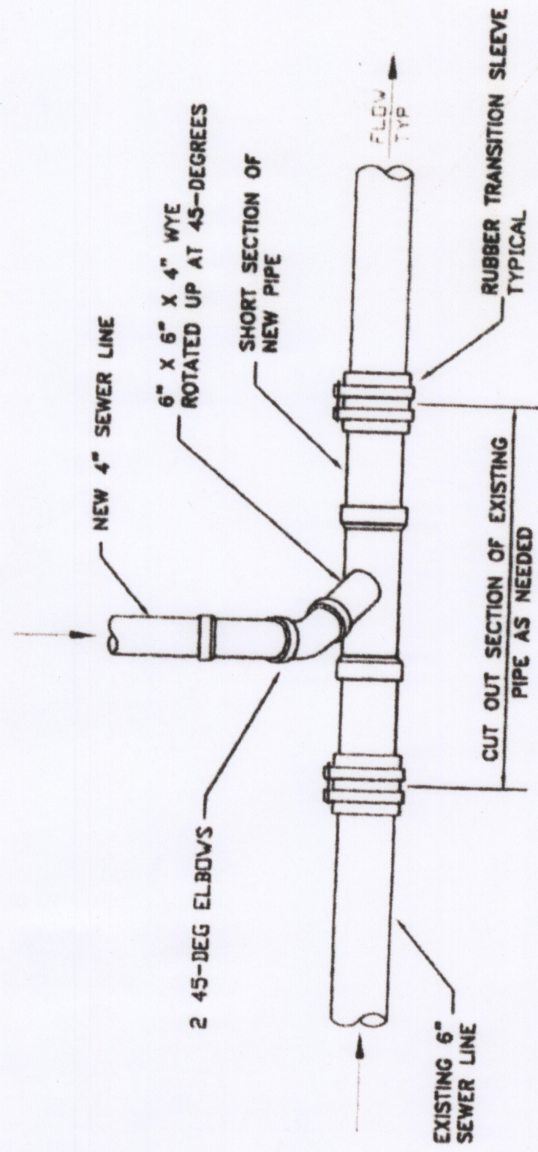


KEYED NOTES

1. CONNECT NEW 4" SEWER TO EXISTING 6" PER DETAIL 1/C4.
2. REMOVE EXISTING 6" CAP. CONNECT NEW 6" WATER LINE (WITH RESTRAINED JOINT HARNESS).
3. INSTALL 4" SEWER SERVICE, CAP, AND MONUMENT FOR FUTURE EXTENSION.
4. INSTALL 6" CAP AND CONCRETE BLOCKING WITH MONUMENT FOR FUTURE EXTENSION.
5. INSTALL 6" 45° CI ELBOW WITH CONCRETE BLOCKING.
6. INSTALL 1" WATER SERVICE LINE, WITH VALVE TO BUILDING SYSTEM PER DETAIL 6/C5.
7. INSTALL 6" GATE VALVE WITH BLOCKING PER DETAIL 3/C5.
8. INSTALL 6" X 6" X 4" CI TEE WITH CONCRETE BLOCKING, 4" GATE VALVE WITH BOX AND BLOCKING PER DETAIL 3/C4, AND 4" FIRE SERVICE LINE TO BUILDING SPRINKLER RISER. NOTE: BACKFLOW PREVENTER TO BE PROVIDED IN RISER.
9. INSTALL ONE-WAY CLEANOUTS AT 100' O.C. MAX. PER DETAIL 5/C5.
10. INSTALL NEW 4" SEWER SERVICE LINE. SLOPE 1% MINIMUM.
11. CONNECT NEW ELECTRICAL SECONDARY FROM EXISTING NPS PROVIDED METER BASE TO BUILDING PANEL. COORDINATE LOCATION WITH ELECTRICAL DRAWINGS AND CONTRACTING OFFICER.
12. CONNECT NEW 1" LP GAS SERVICE LINE TO EXISTING MANIFOLD AT LP GAS TANKS. LINE SHALL BE AS APPROVED BY LOCAL CODES.
13. CUT AND PATCH APPROXIMATELY 45 FEET OF ASPHALT PAVEMENT.
14. PROPOSED ROUTING FOR TELEPHONE AND IT SERVICES. 4" CONDUIT WITH PULL WIRE. COORDINATE LOCATION WITH CONTRACTING OFFICER.

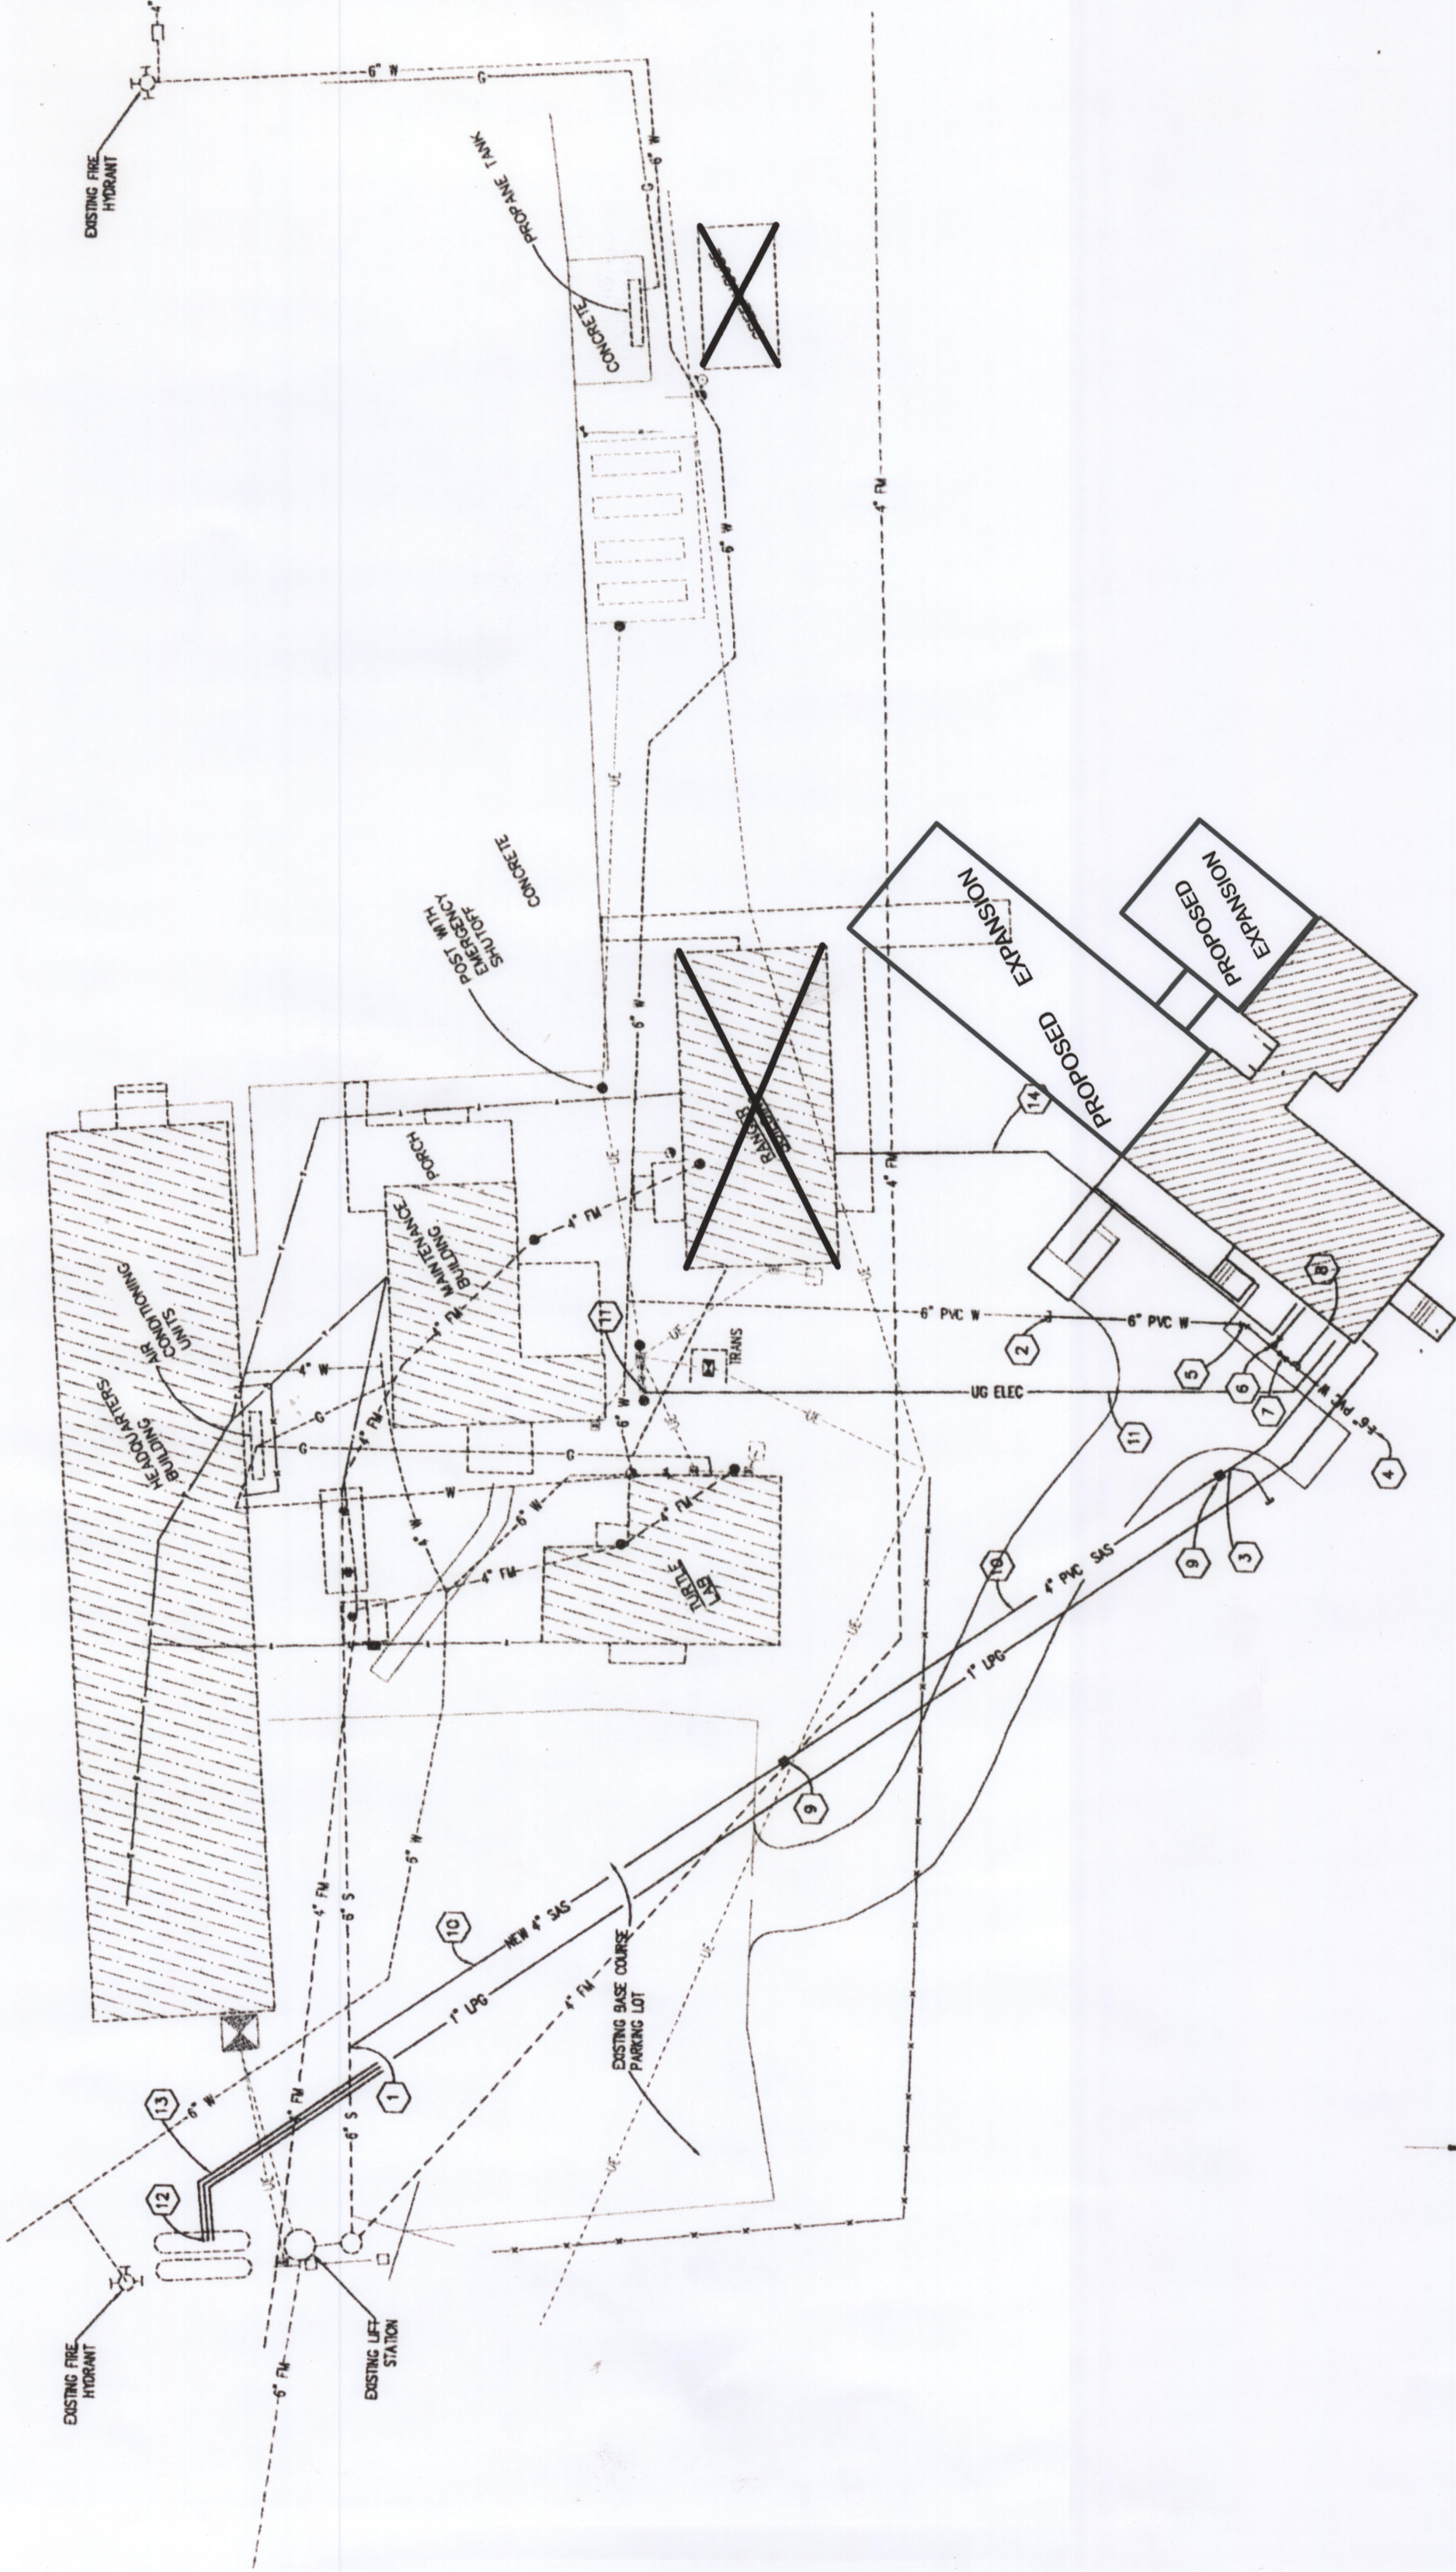

1/24 SEWER SERVICE TO MAIN - PLAN VIEW



DESIGNED: LRA GAB	SUB SHEET NO. C3	TITLE OF SHEET UTILITY EXTENSION PLAN TURTLE LABORATORY	DRAWING NO. 613
TECH. REVIEW: LDR	DATE 08/23/04	PADRE ISLAND NATIONAL SEASHORE	PKG. NO. 80036
			SHEET NO. 4
			OF 36